








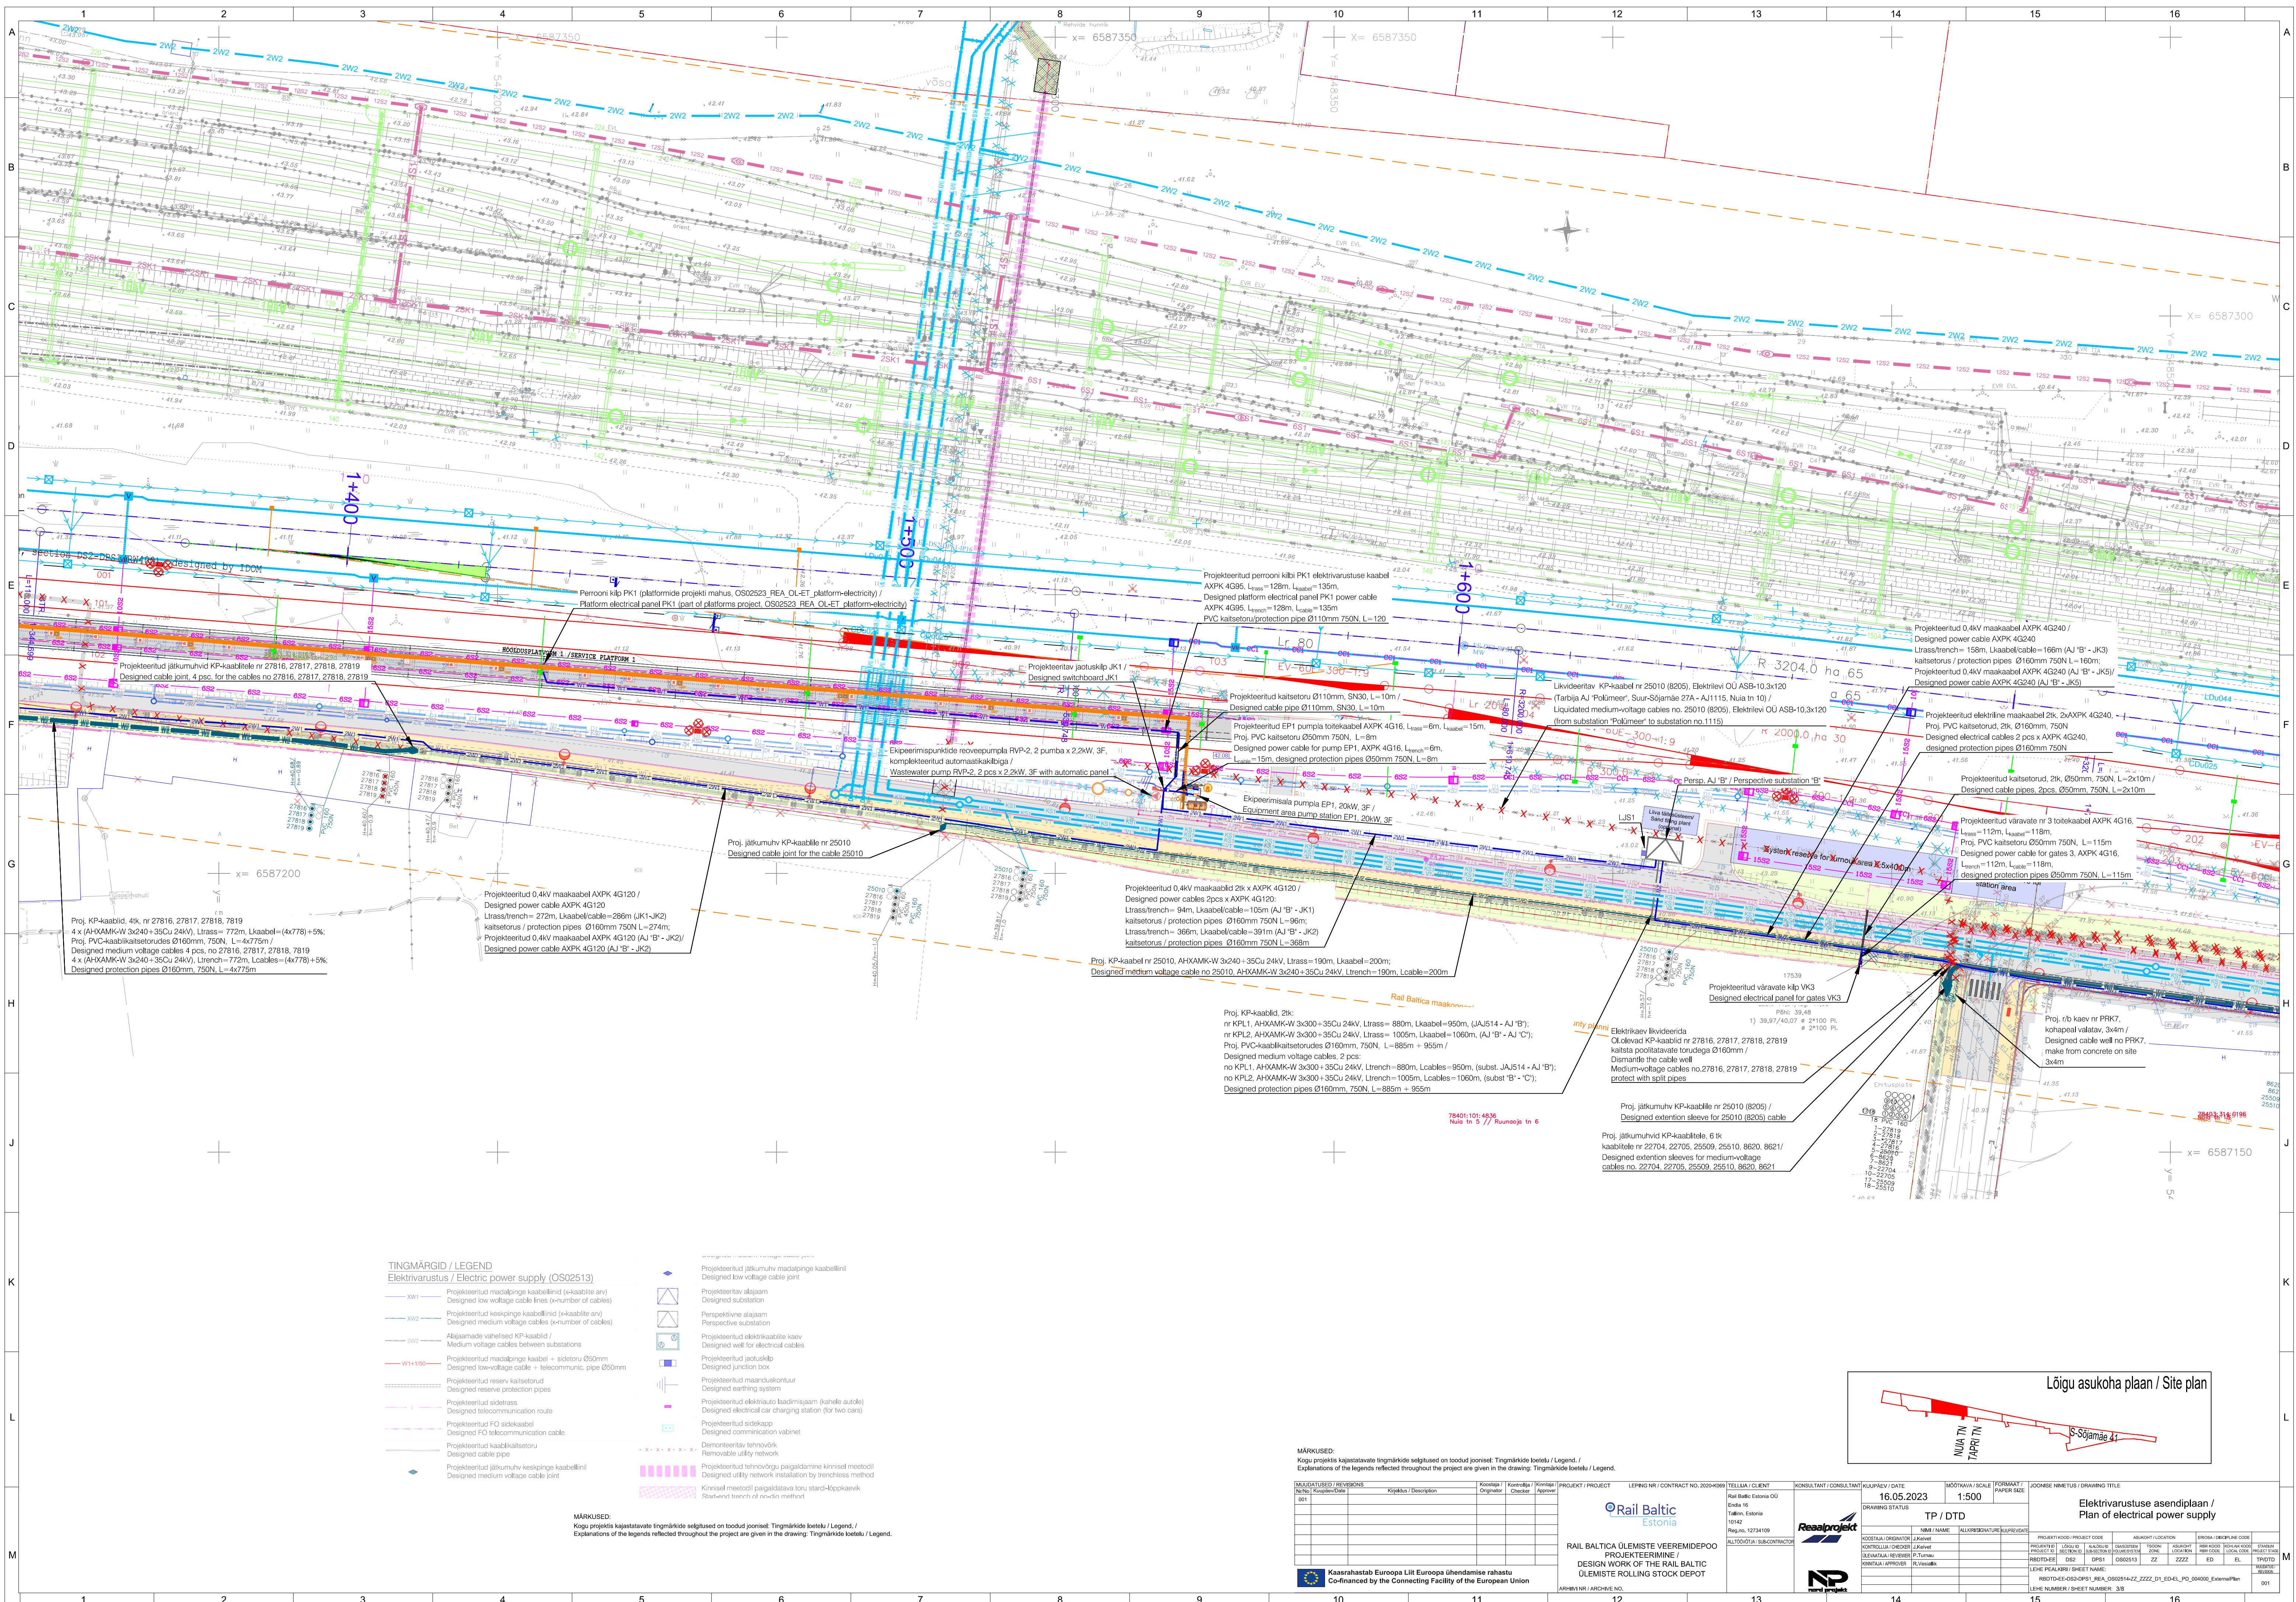

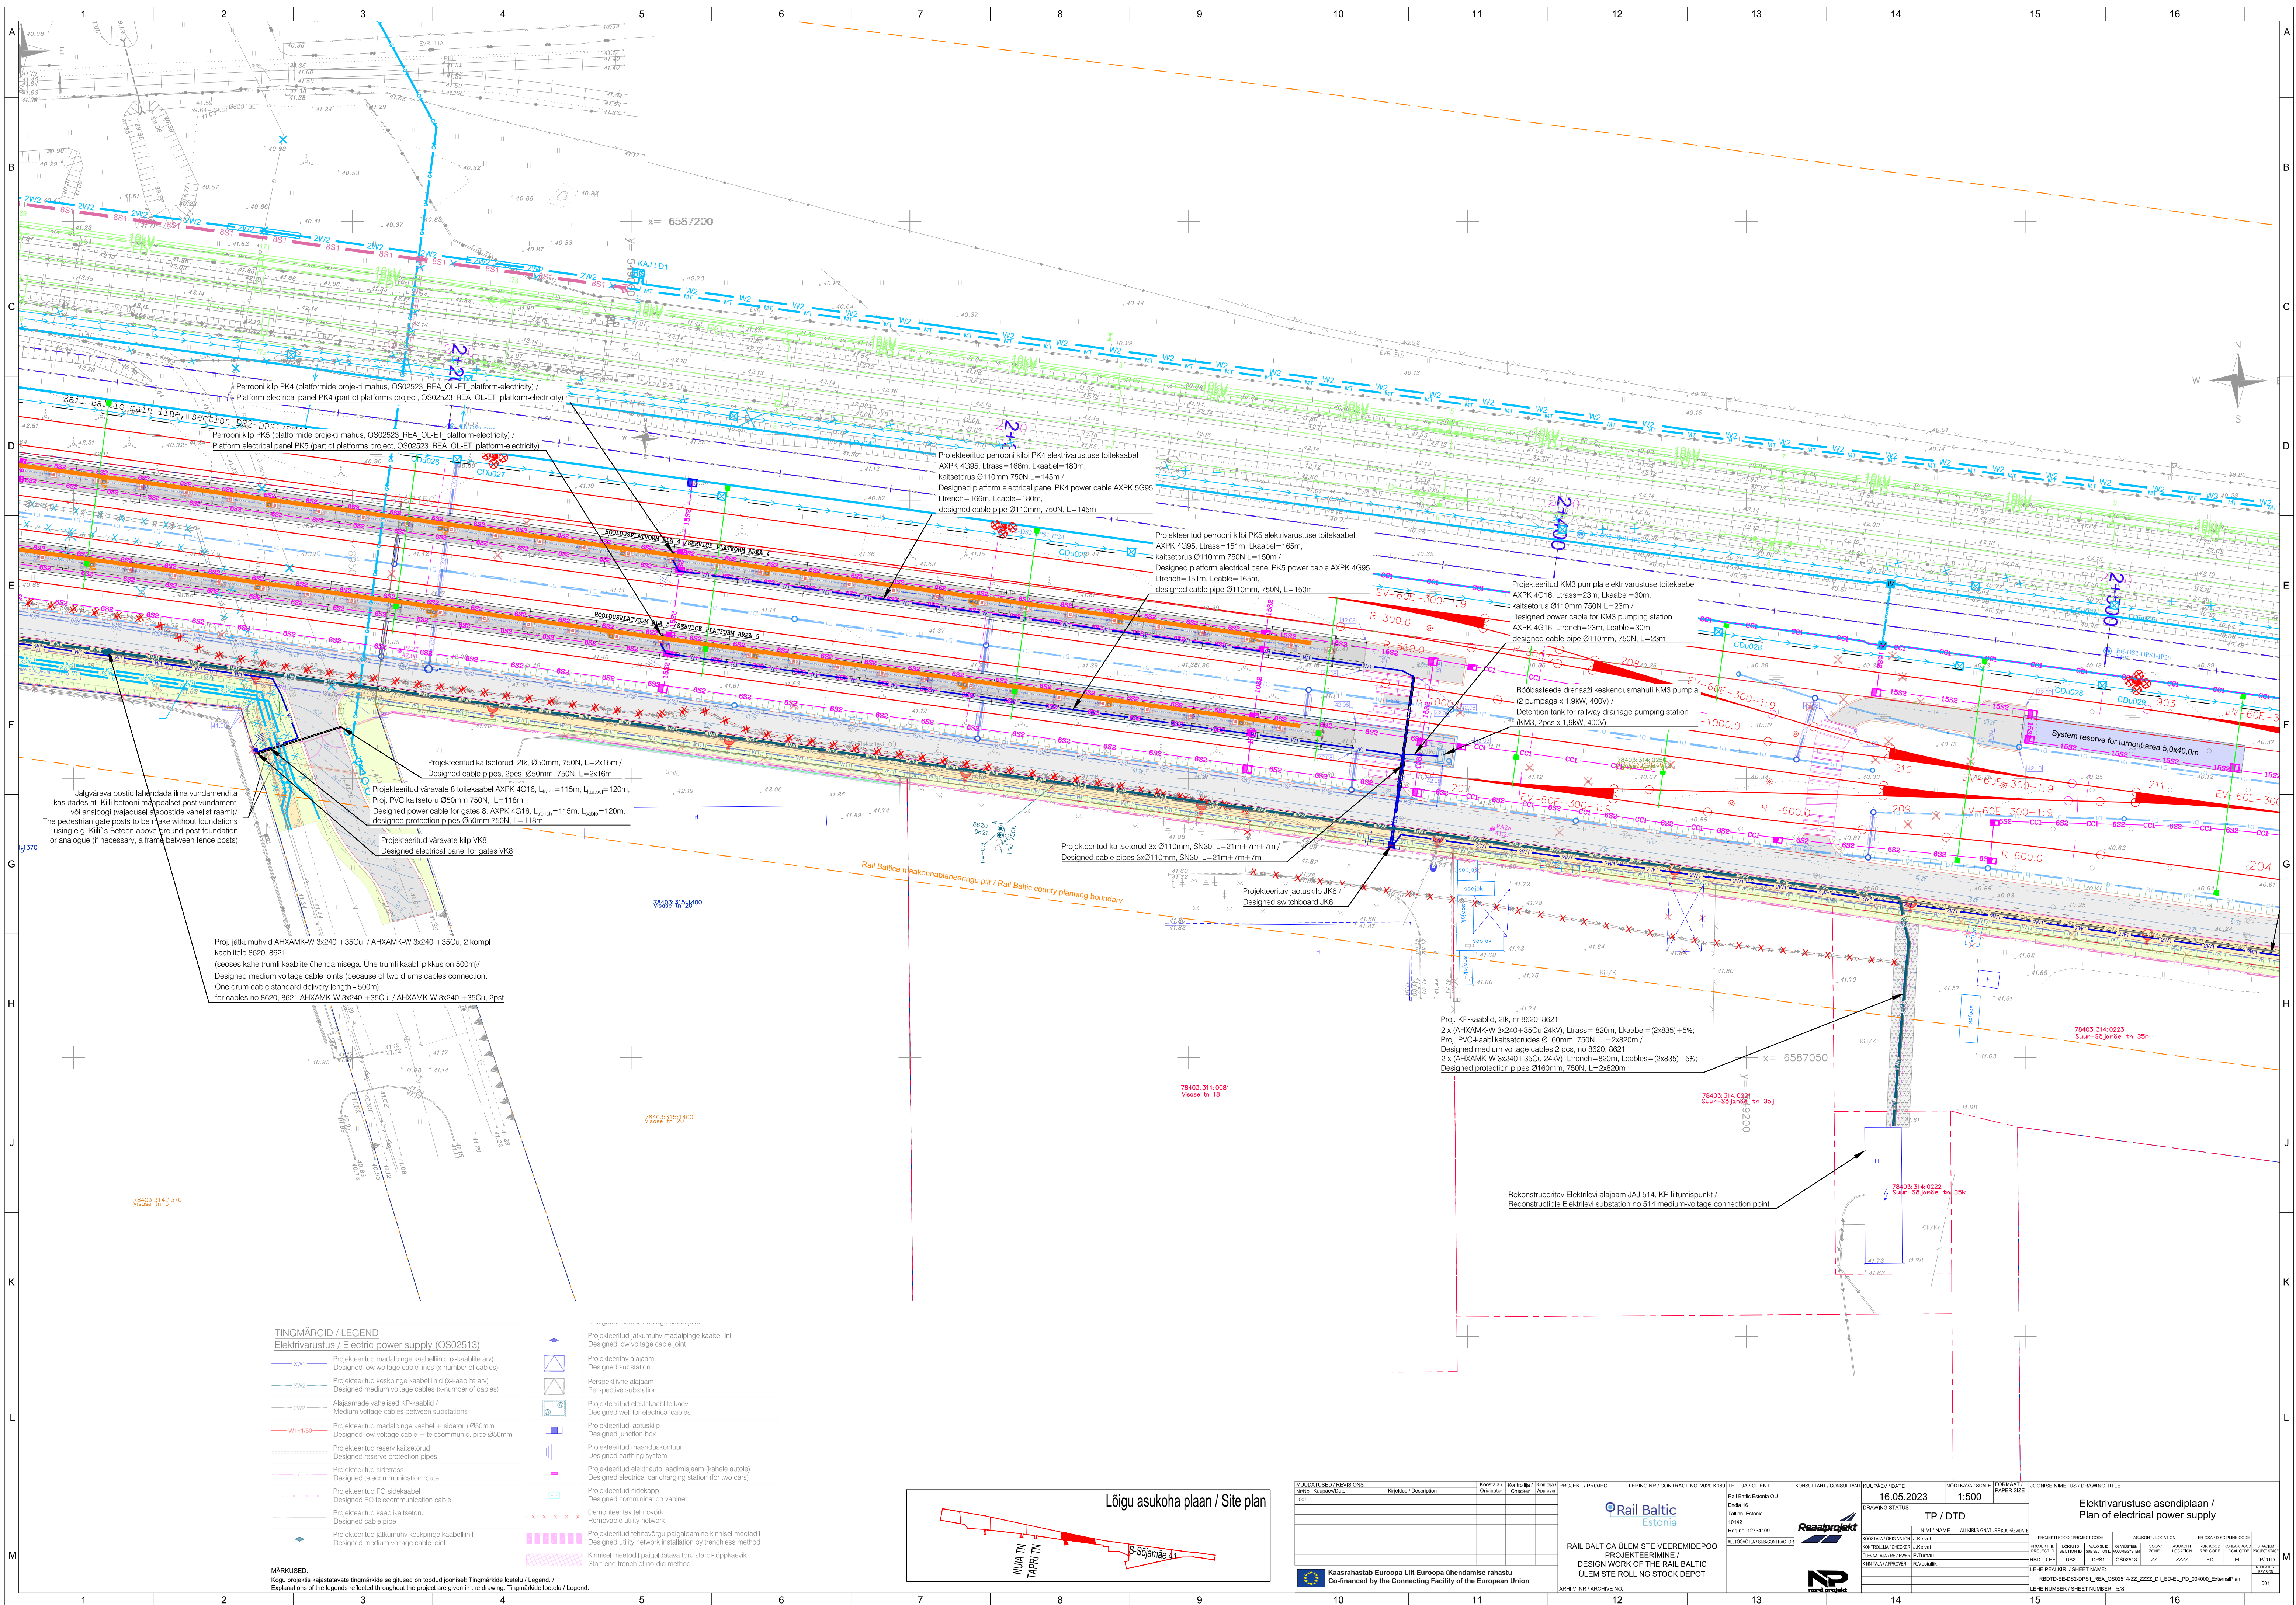

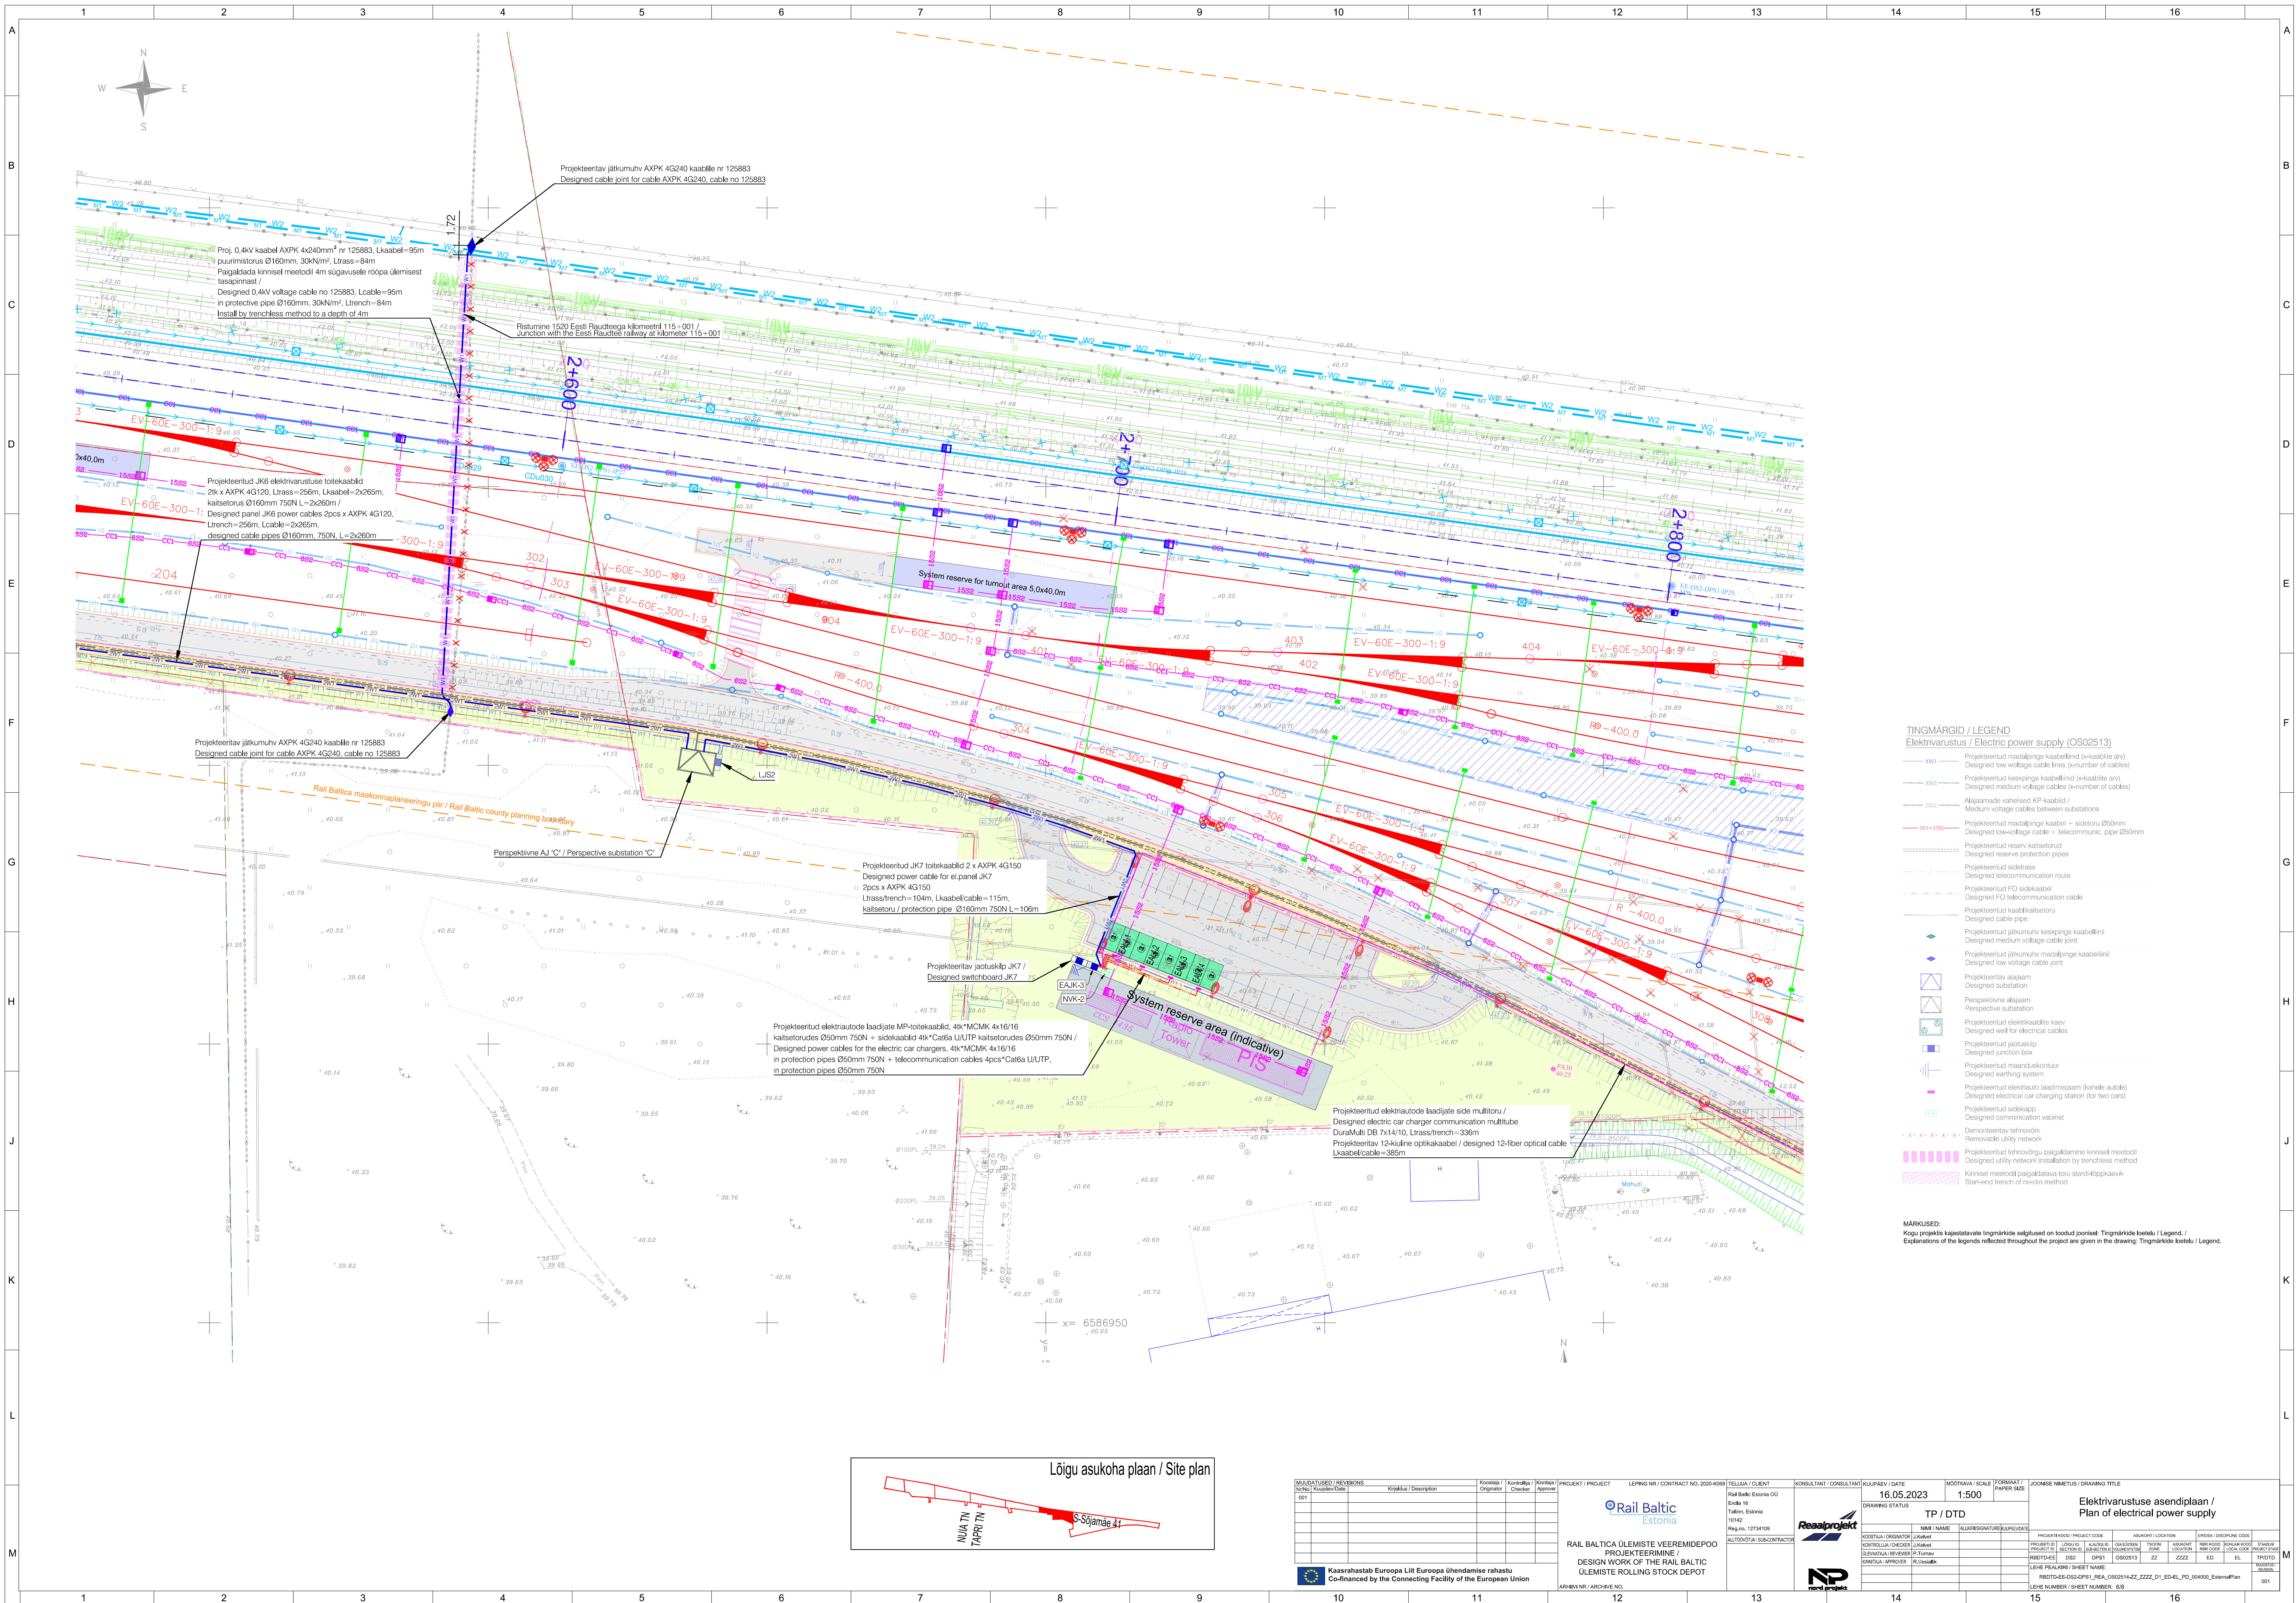

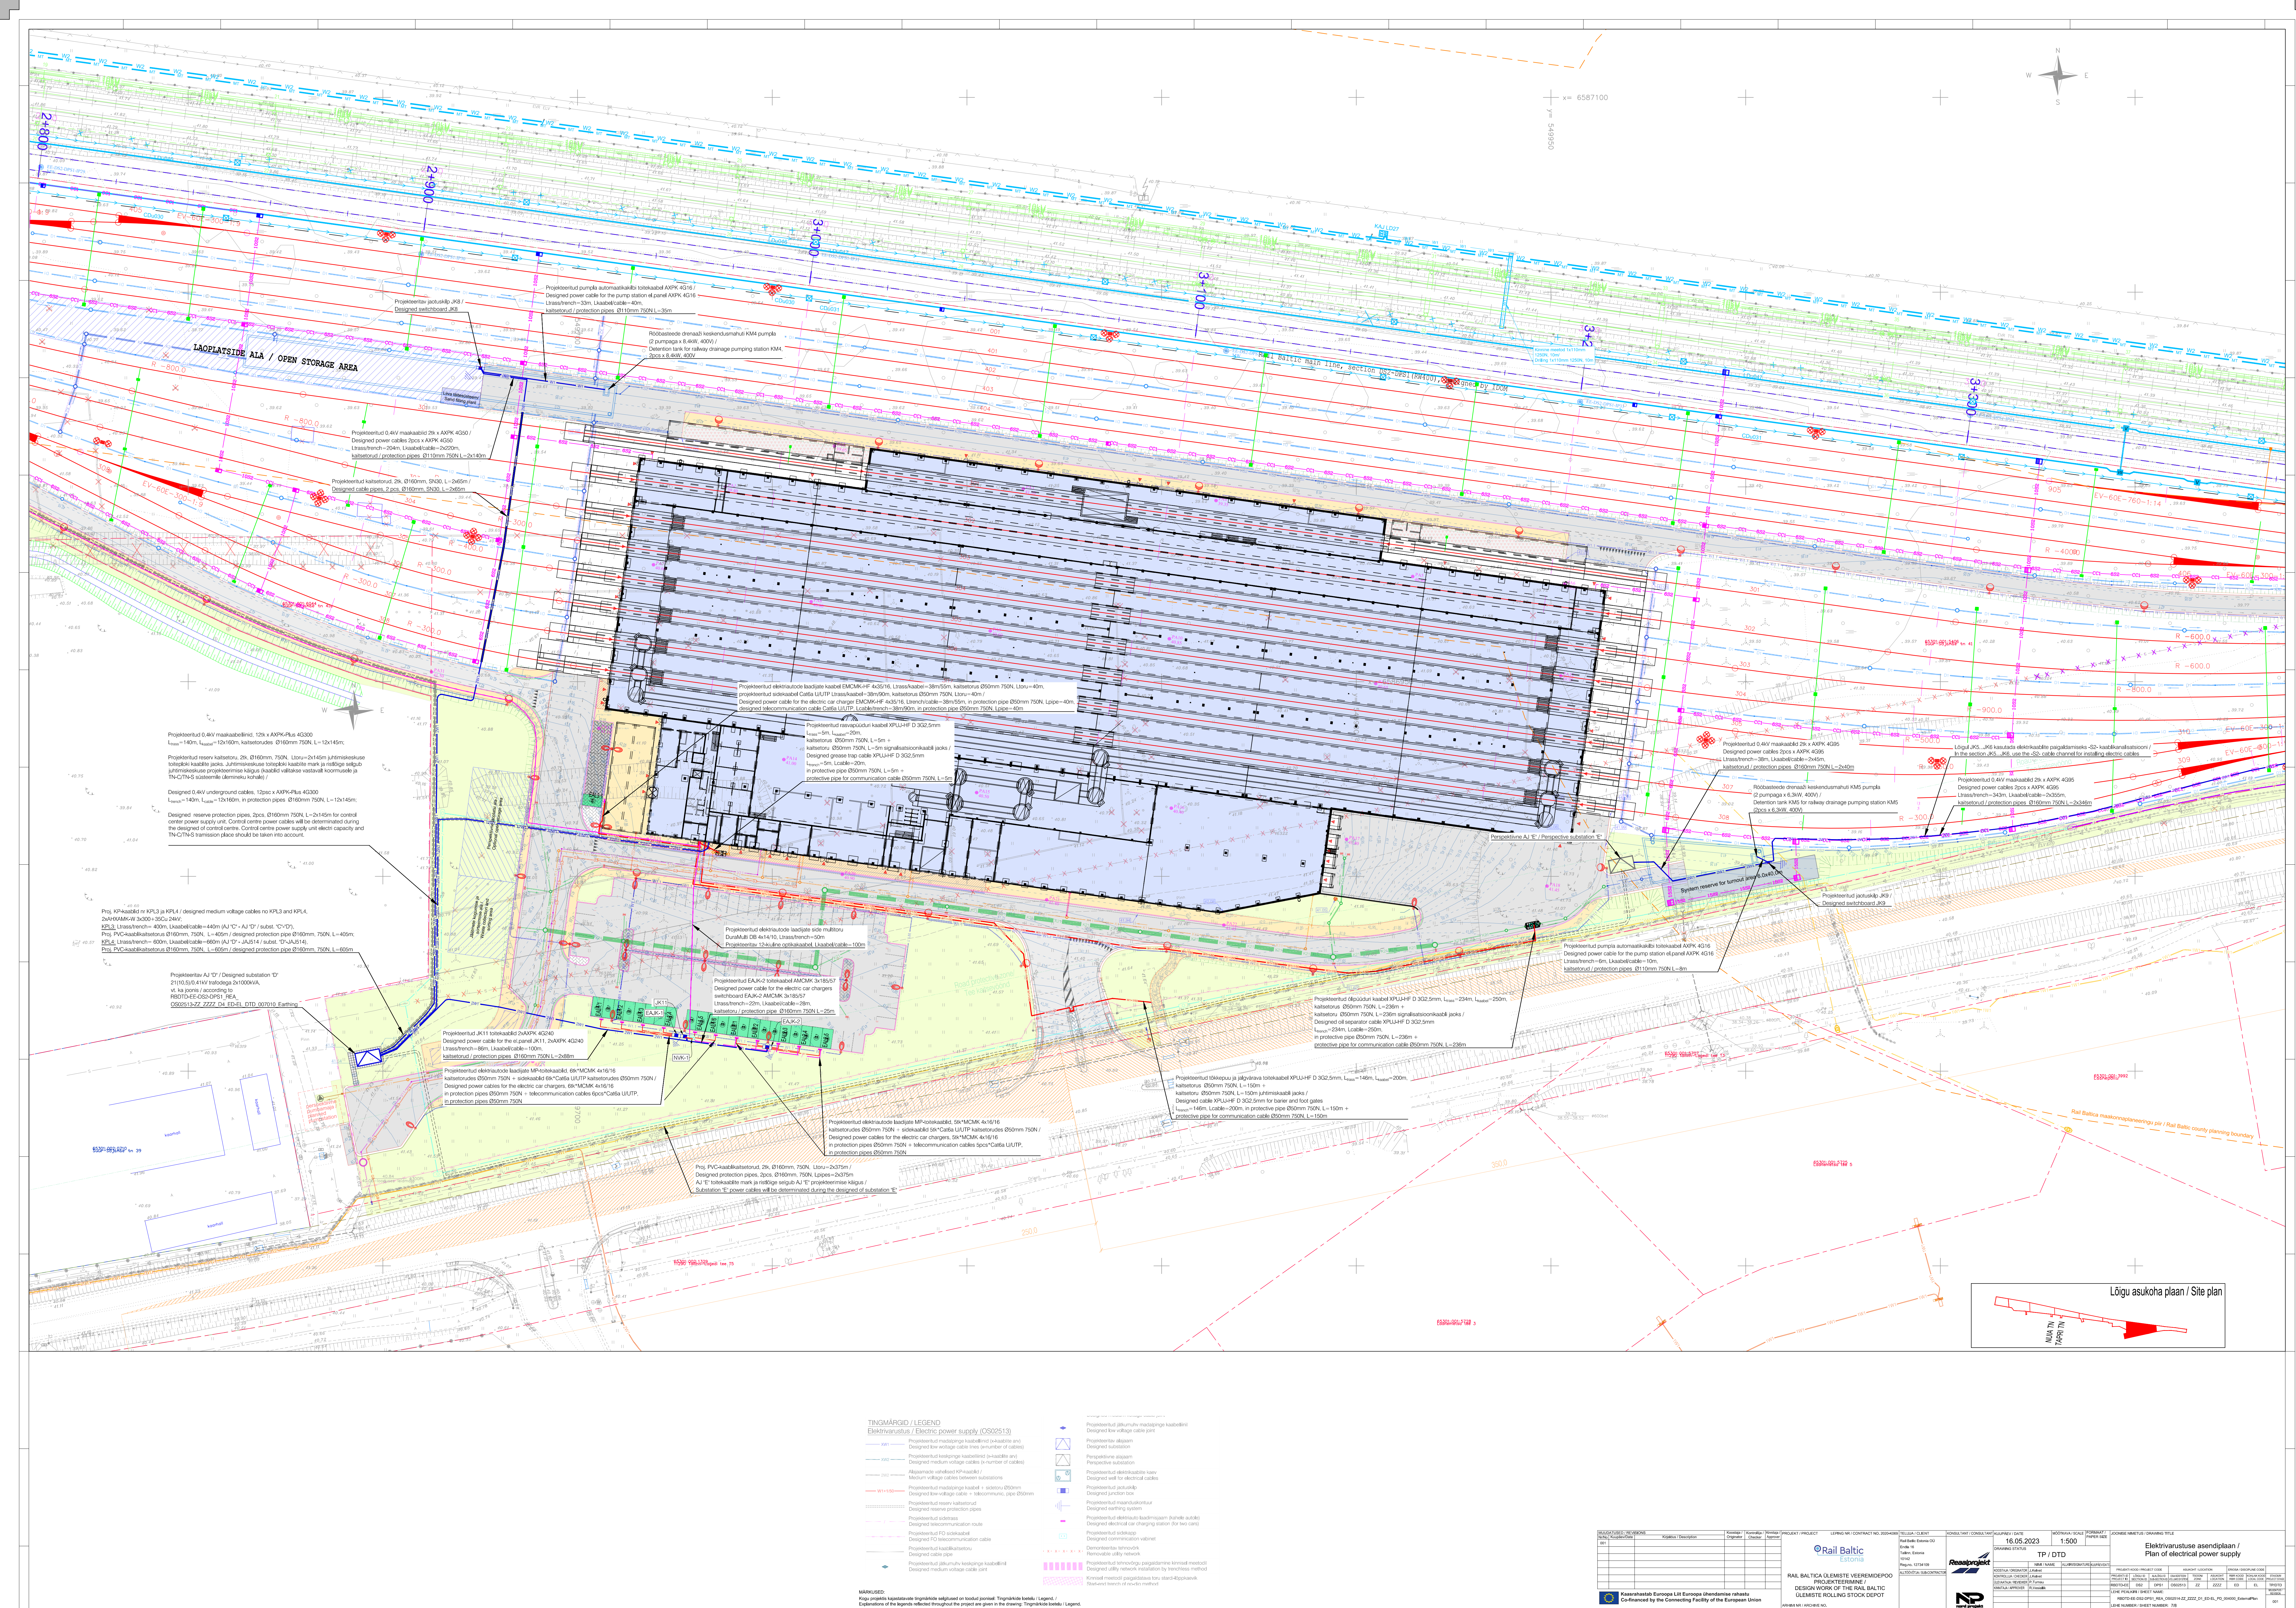

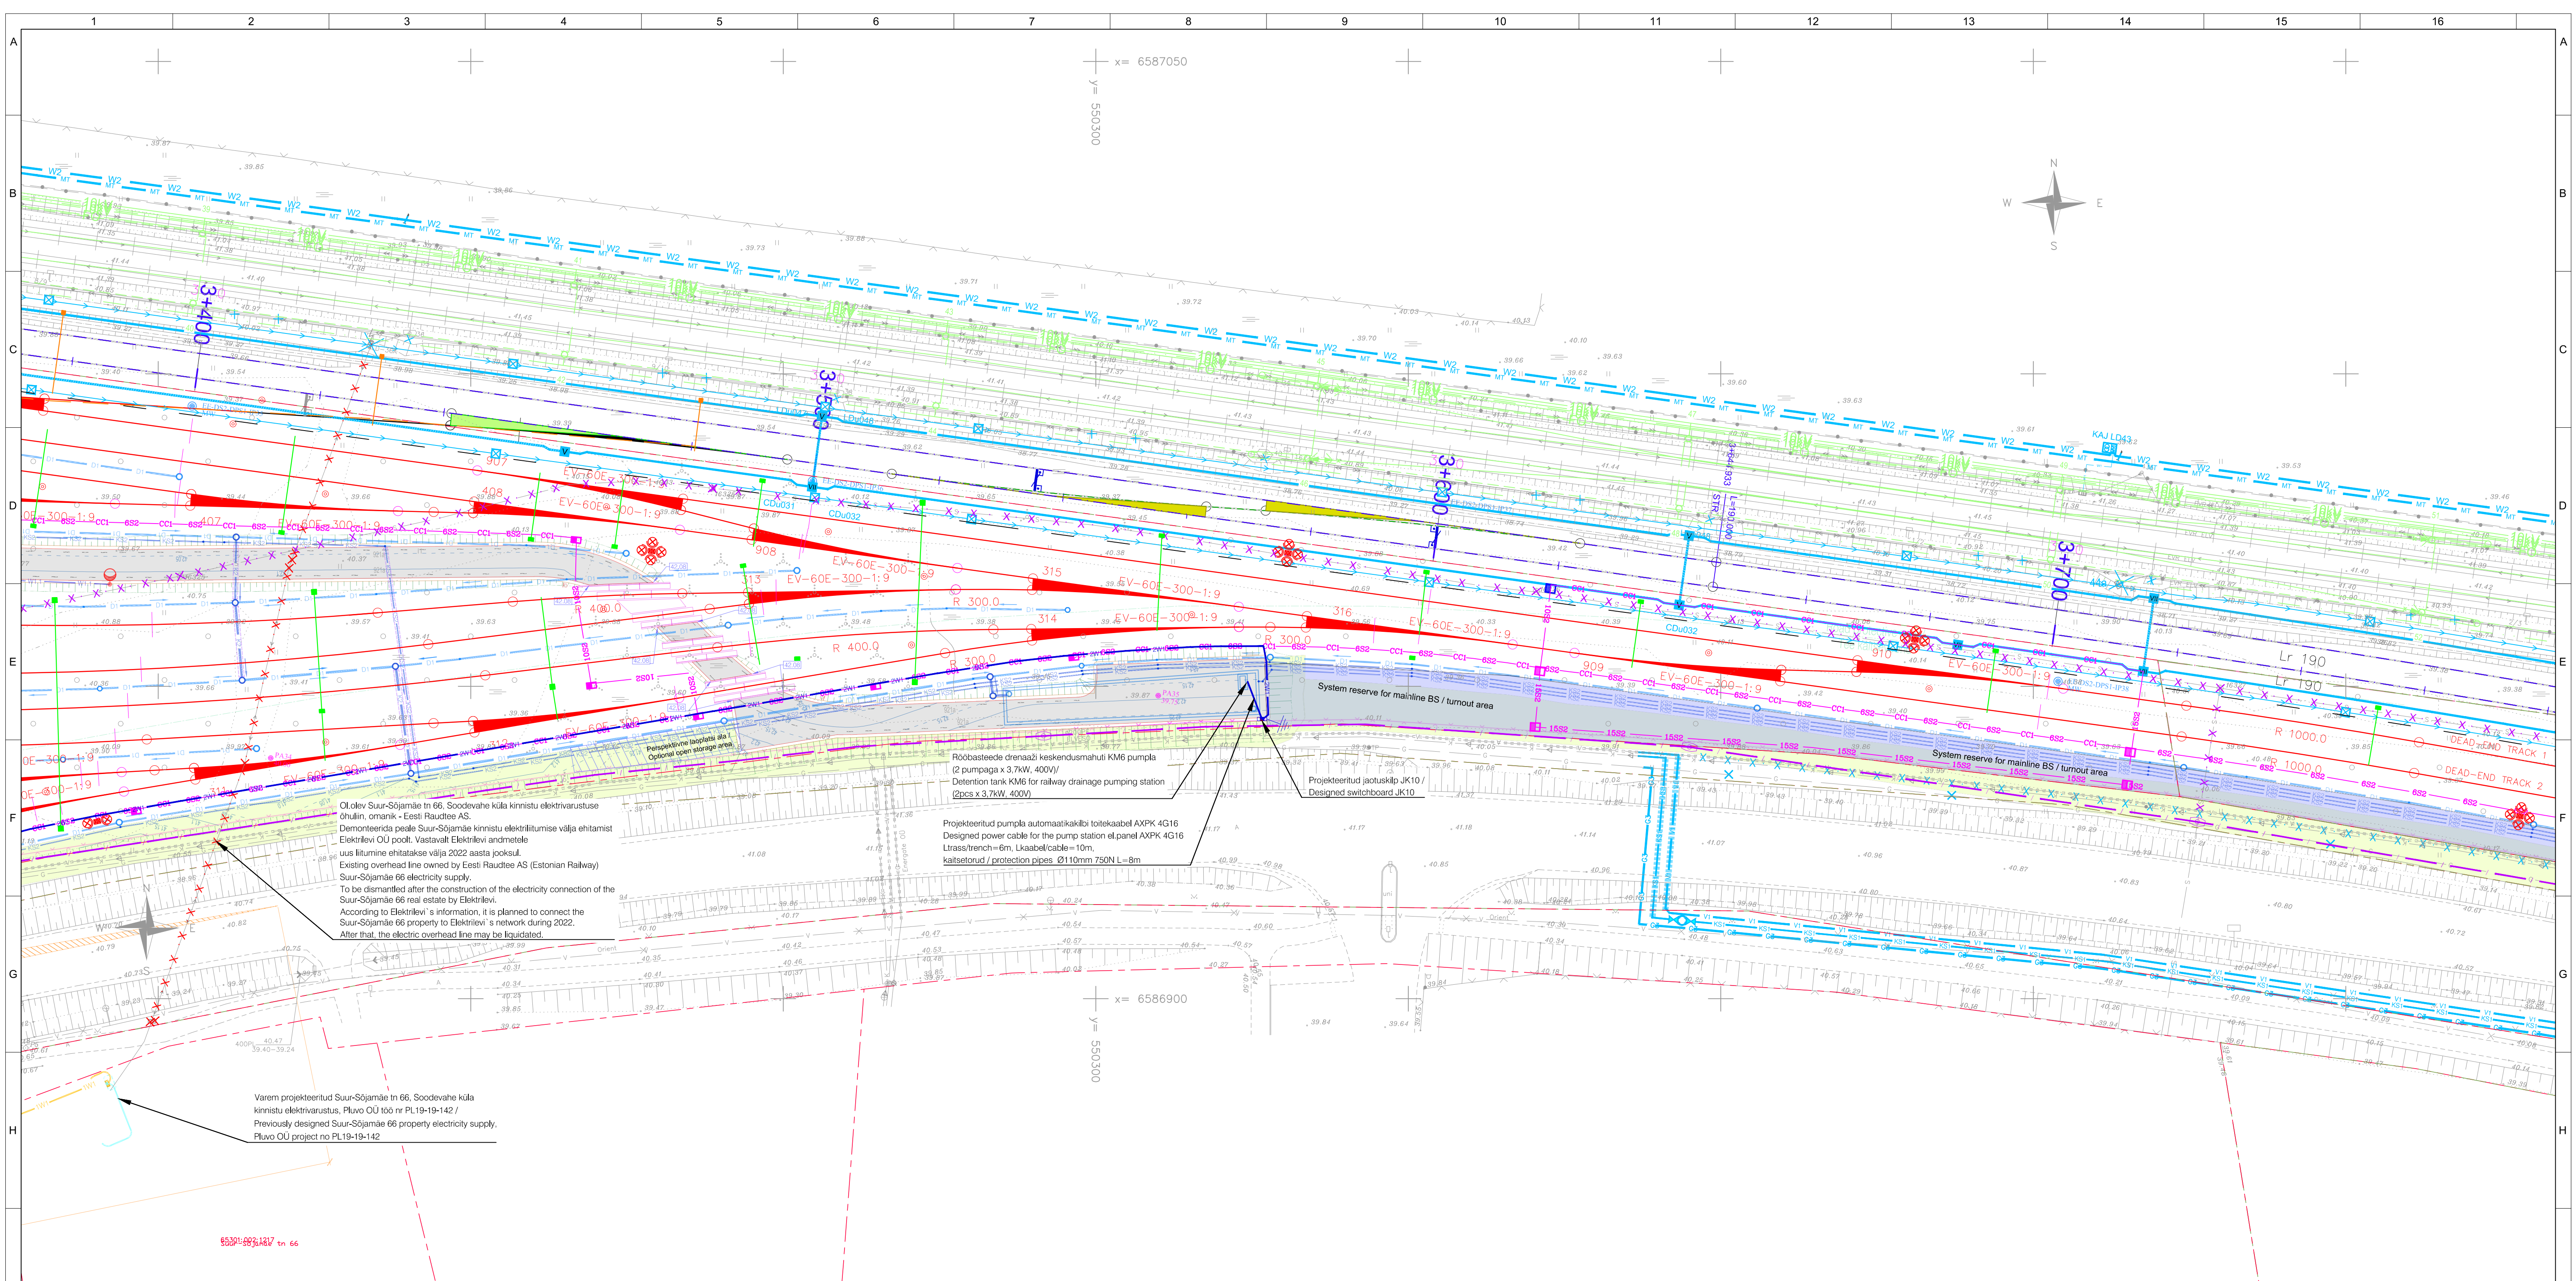

TINGMÄRGID / LEGEND
Elektrivarustus / Electric power supply (OS02513)

—XW1—	Projekteeritud madalpinge kaabellinid (x-kaablate arv) Designed low voltage cable lines (x-number of cables)	◆	Projekteeritud jätkumuhv madalpinge kaabellini Designed low voltage cable joint
—XW2—	Projekteeritud keskpinge kaabellinid (x-kaablate arv) Designed medium voltage cable lines (x-number of cables)	□	Projekteeritud alajaam Designed substation
—W2—	Alajaamade vahetamiseks KP-kaablid / Medium voltage cables between substations	□	Perspektiivne alajaam Perspective substation
—W1+150—	Projekteeritud madalpinge kaabel + sidetoru Ø50mm Designed low-voltage cable + telecommunic. pipe Ø50mm	□	Projekteeritud elektrikaablate kaev Designed well for electrical cables
-----	Projekteeritud reserv kaitseturud Designed reserve protection pipes	□	Projekteeritud jaotuskiip Designed junction box
---	Projekteeritud sidetass Designed telecommunication route	□	Projekteeritud maanduskontuur Designed earthing system
---	Projekteeritud FD sidekaabel Designed FD telecommunication cable	□	Projekteeritud elektriauto laadimisjaam (kahels autole) Designed electrical car charging station (for two cars)
---	Projekteeritud kaabalkaitsetoru Designed cable protection	□	Projekteeritud sidekaap Designed communication cabinet
---	Projekteeritud jätkumuhv keskpinge kaabellini Designed medium voltage cable joint	□	Demonteeritav tehnovõrk Removable utility network
		□	Projekteeritud tehnovõrgu paigaldamine kinnisel meetodil Designed utility network installation by trenchless method
		□	Kinnisel meetodil paigaldatava toru stard-õppkaevik Start-trench of trenchless method

MARKUSED:
Kogu projekti kajastatavate tingimärkide selgitused on toodud joonisel: Tingimärkide loetelu / Legend. /
Explanations of the legends reflected throughout the project are given in the drawing: Tingimärkide loetelu / Legend.

Lõigu asukoha plaan / Site plan

TEKSTI LOETELU / REVISIONS	Koostaja / Originator	Kontrolli / Checker	Heitja / Approver	PROJEKT / PROJECT	LEPING NR / CONTRACT NO. 2024-0098	TELLUJA / CLIENT	KONSULTANT / CONSULTANT	KULUPÄEV / DATE	MÕÕTKAALA / SCALE	FORMAAT / PAPER SIZE	JOONISE NIMETUS / DRAWING TITLE
No: 001	Kuusküla / Kuusküla					Rail Baltic Estonia OÜ	Reaalprojekt	16.05.2023	1:500	TP / DTD	Elektrivarustus asendiplaan / Plan of electrical power supply
				RAIL BALTICA ÜLEMISTE VEEREMIDEEPÕ PROJEKTEERIMINE / DESIGN WORK OF THE RAIL BALTIC ÜLEMISTE ROLLING STOCK DEPOT		Reaalprojekt				PROJECT CODE / PROJECT CODE	
				Kasrahaastab Euroopa Liit Euroopa ühendamise rahastu Co-financed by the Connecting Facility of the European Union		Reaalprojekt				PROJECT CODE / PROJECT CODE	
				ARCHIVE NR / ARCHIVE NO.		Reaalprojekt				PROJECT CODE / PROJECT CODE	